
 


PO BOX 151178 • ELY, NEVADA 89315 • (775) 289-5353
 63 KEYSTONE AVENUE #206 • RENO, NEVADA 89503 • (775) 348-8624

BLM PLAN OF DEVELOPMENT
NEW WATER STORAGE TANK SITE
AUSTIN WATER SYSTEM IMPROVEMENTS

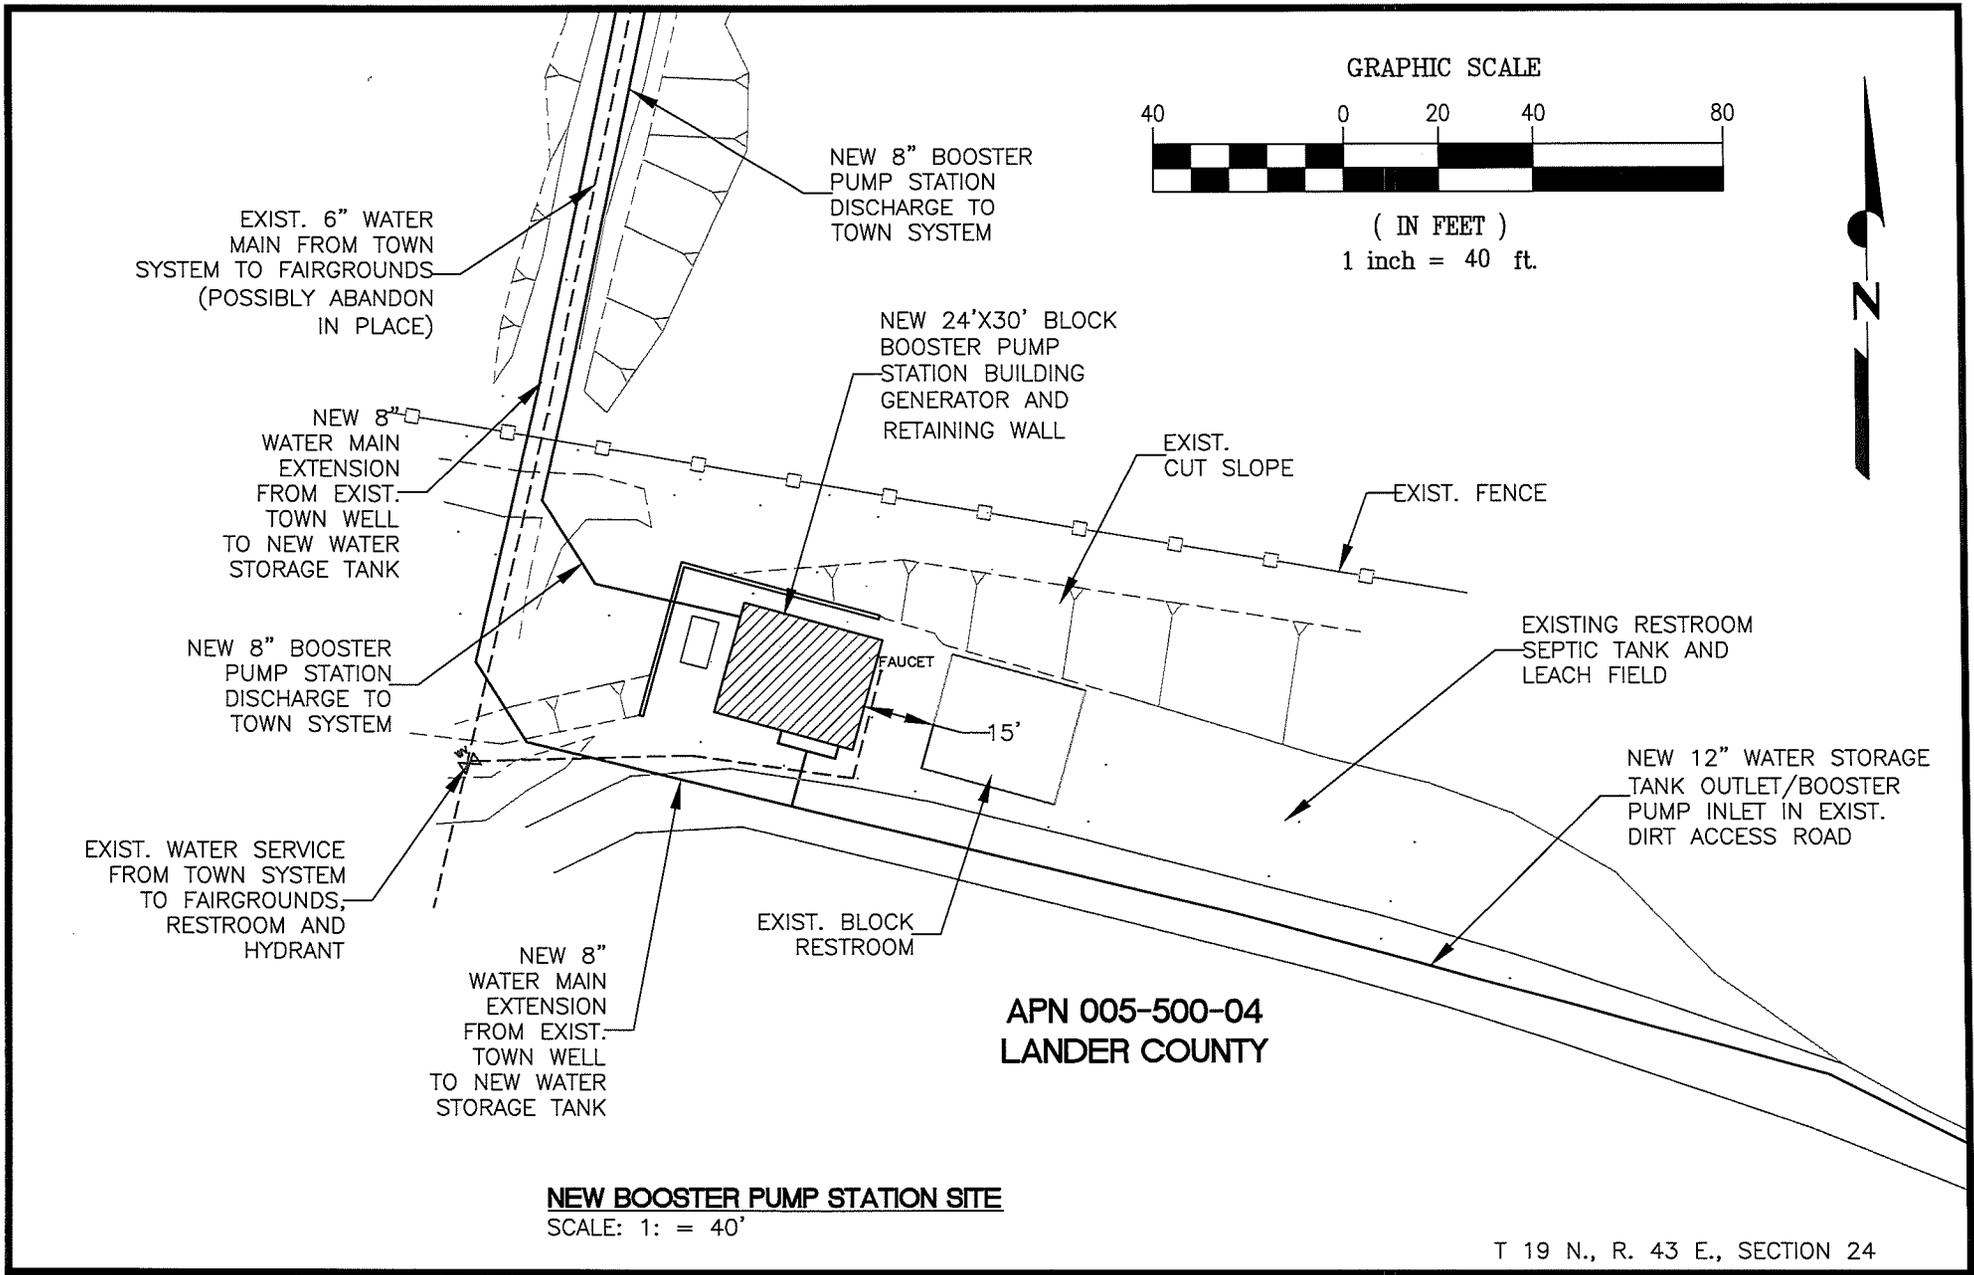

GRAPHIC SCALE



(IN FEET)
1 inch = 40 ft.



NEW BOOSTER PUMP STATION SITE
SCALE: 1" = 40'


APN 005-500-04
LANDER COUNTY

T 19 N., R. 43 E., SECTION 24





PO BOX 151178 • ELY, NEVADA 89315 • (775) 289-5353
63 KEYSTONE AVENUE #206 • RENO, NEVADA 89503 • (775) 348-8624

BLM PLAN OF DEVELOPMENT
NEW BOOSTER PUMP STATION SITE
AUSTIN WATER SYSTEM IMPROVEMENTS

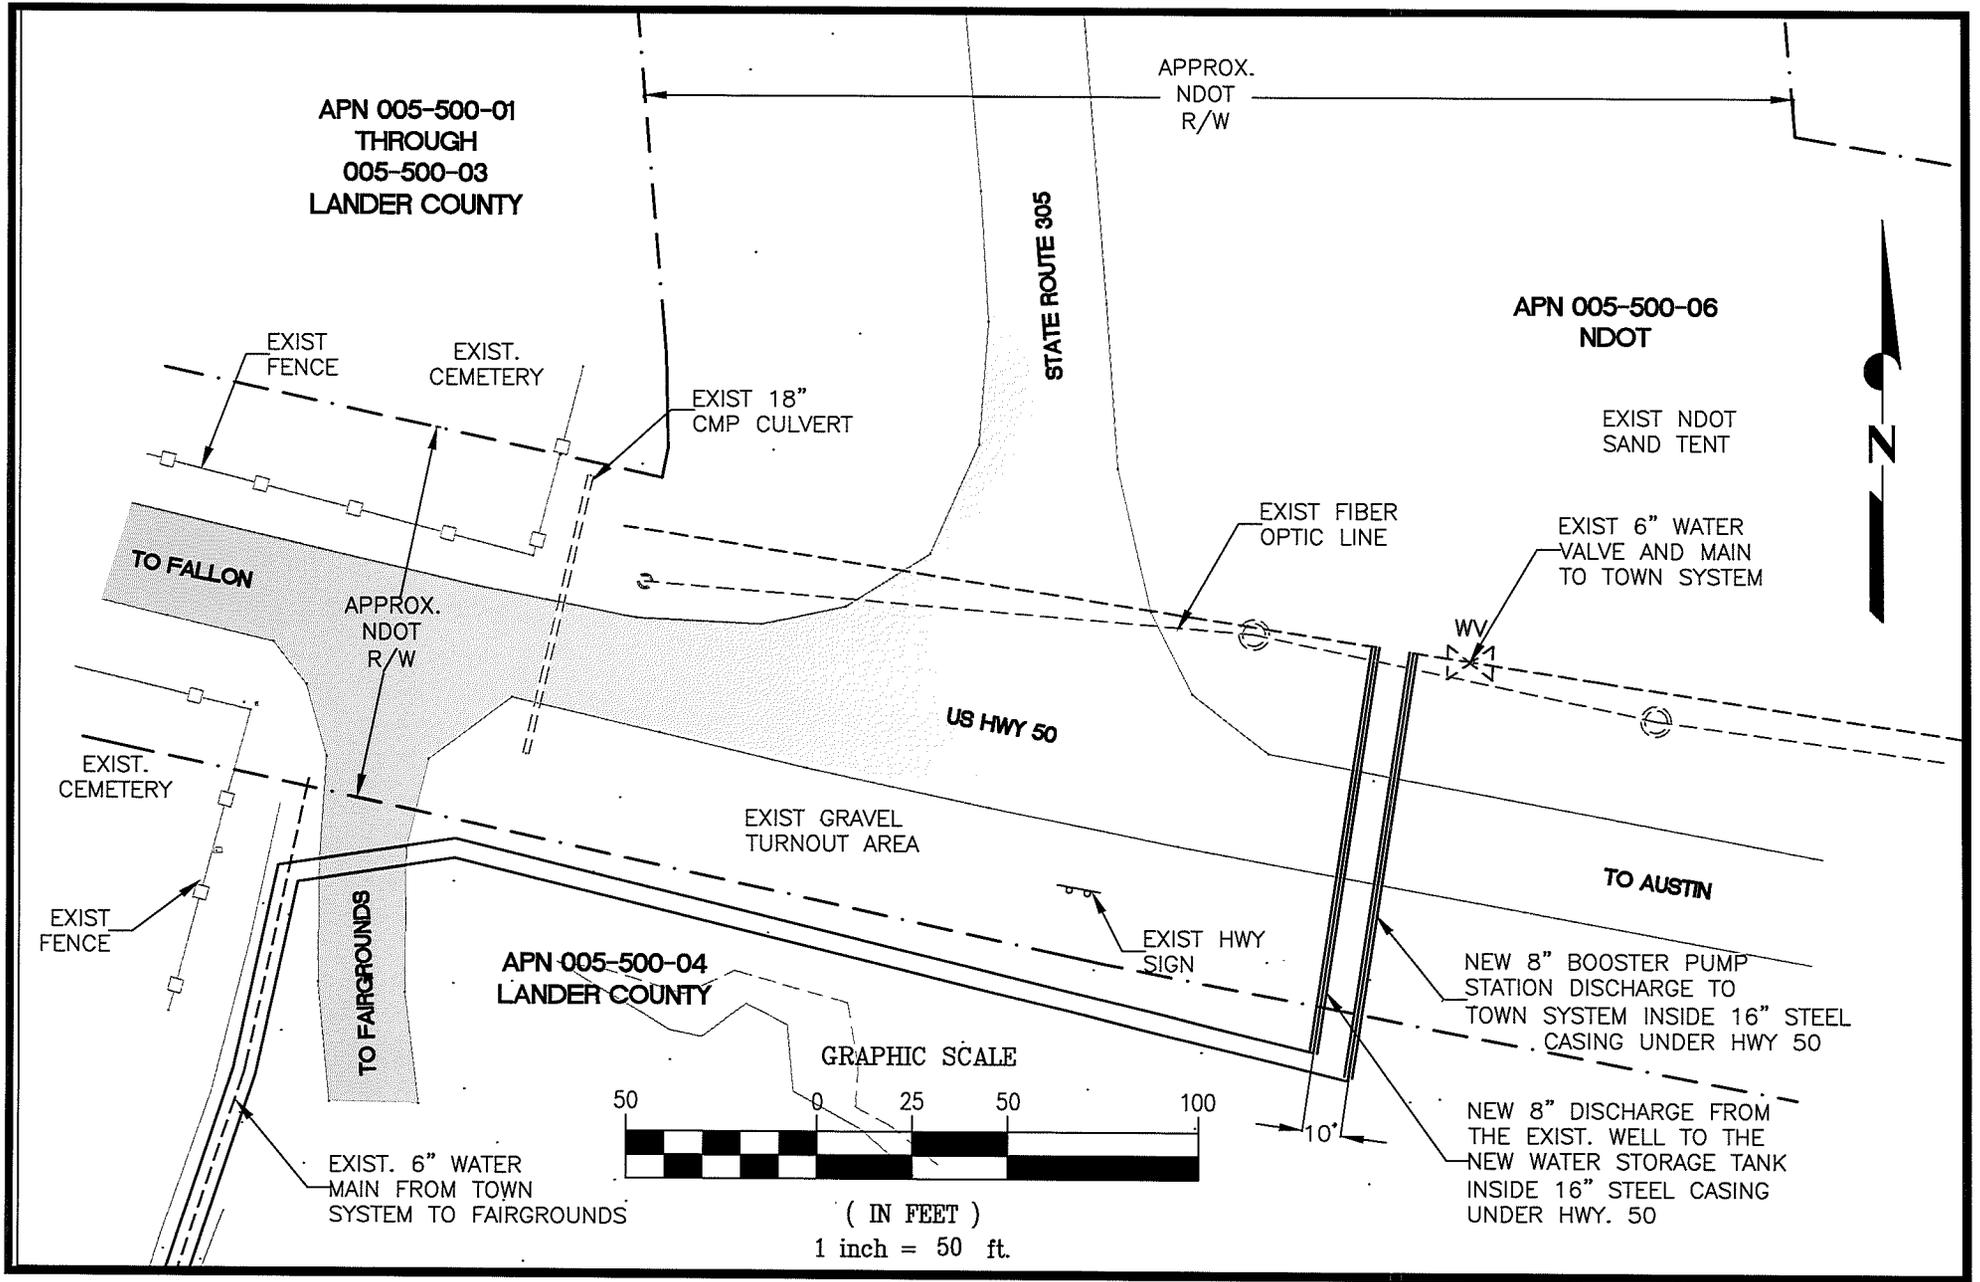

PO BOX 151178 • ELY, NEVADA 89315 • (775) 289-5353
 63 KEYSSTONE AVENUE #206 • RENO, NEVADA 89503 • (775) 348-8624

**BLM PLAN OF DEVELOPMENT
 HWY 50 WATER MAIN CROSSING
 AUSTIN WATER SYSTEM IMPROVEMENTS**

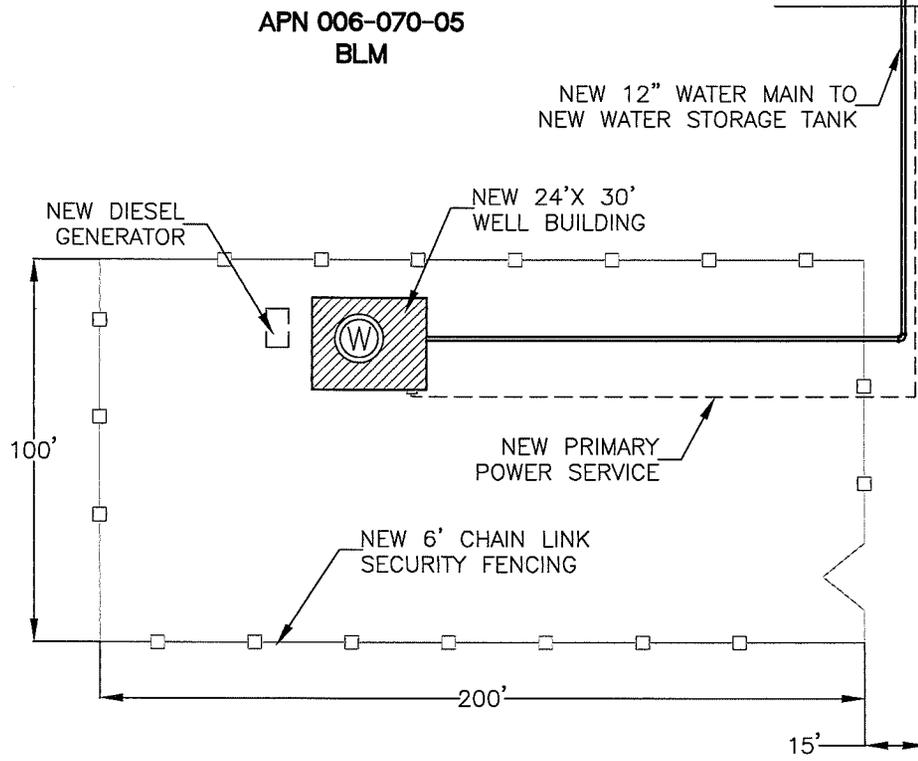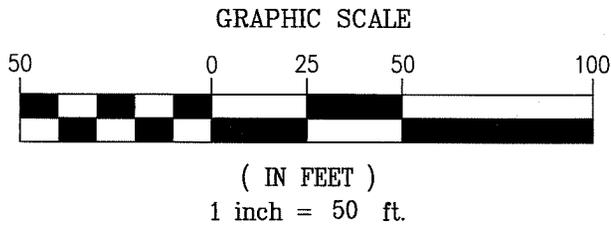

APPROX. 2.1 MILES
TO SR 722

COUNTY-MAINTAINED
DIRT ROAD

APPROX. 230' TO
EAST CENTER OF
SECTION 7

CHAMPIE
PROPERTY LINE


APN 006-070-02
JAMES CHAMPIE JR.

T. 18 N., R. 43 E., SECTION 7



PO BOX 151178 • ELY, NEVADA 89315 • (775) 289-5353
63 KEYSTONE AVENUE #206 • RENO, NEVADA 89503 • (775) 348-8624

BLM PLAN OF DEVELOPMENT
NEW WELL SITE
AUSTIN WATER SYSTEM IMPROVEMENTS

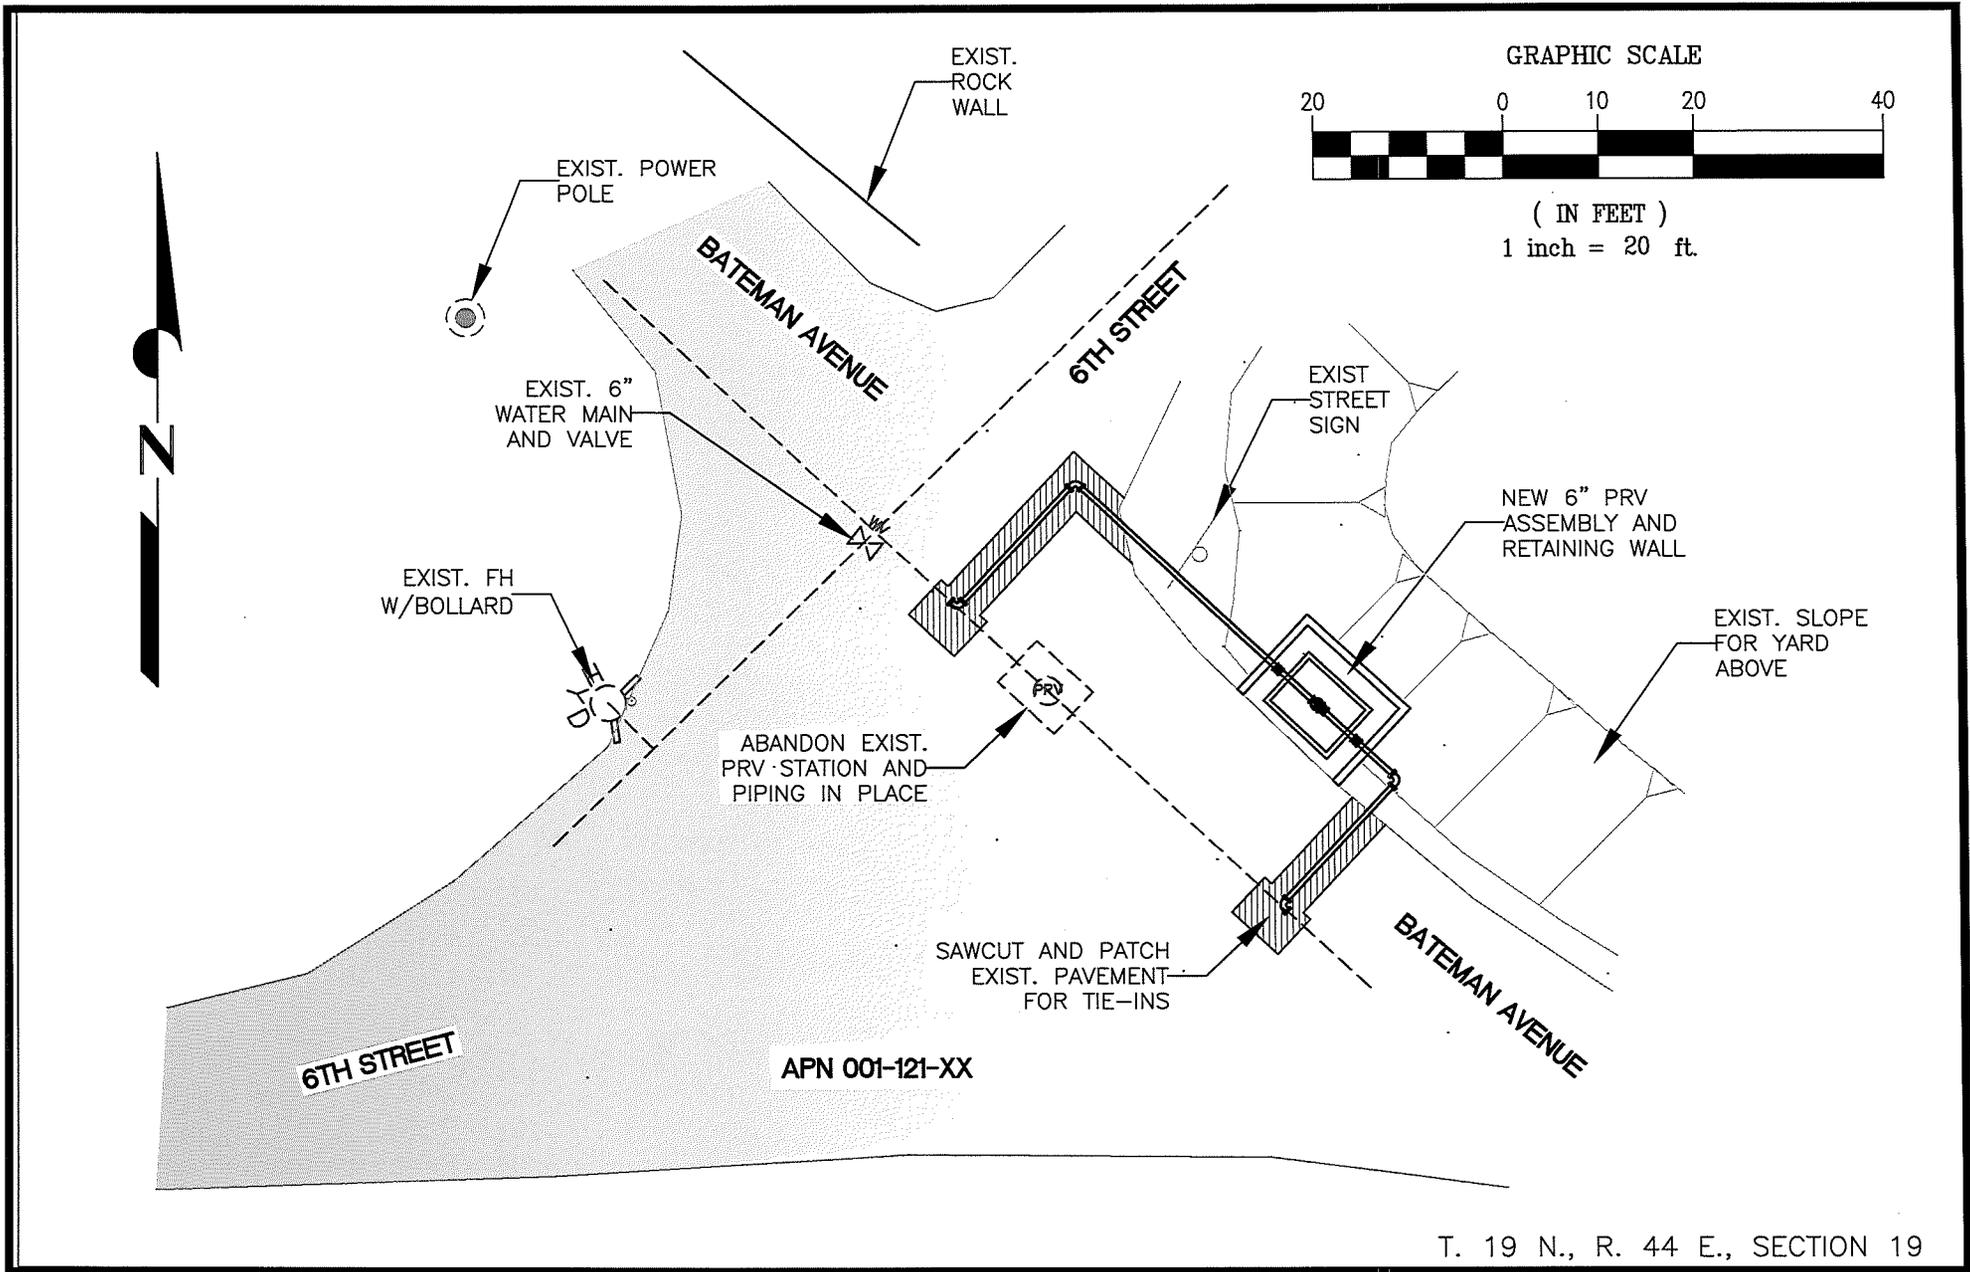


T. 19 N., R. 44 E., SECTION 19




PO BOX 151178 • ELY, NEVADA 89315 • (775) 289-5353
 63 KEYSTONE AVENUE #206 • RENO, NEVADA 89503 • (775) 348-8624

BLM PLAN OF DEVELOPMENT
NEW PRV SITE
AUSTIN WATER SYSTEM IMPROVEMENTS

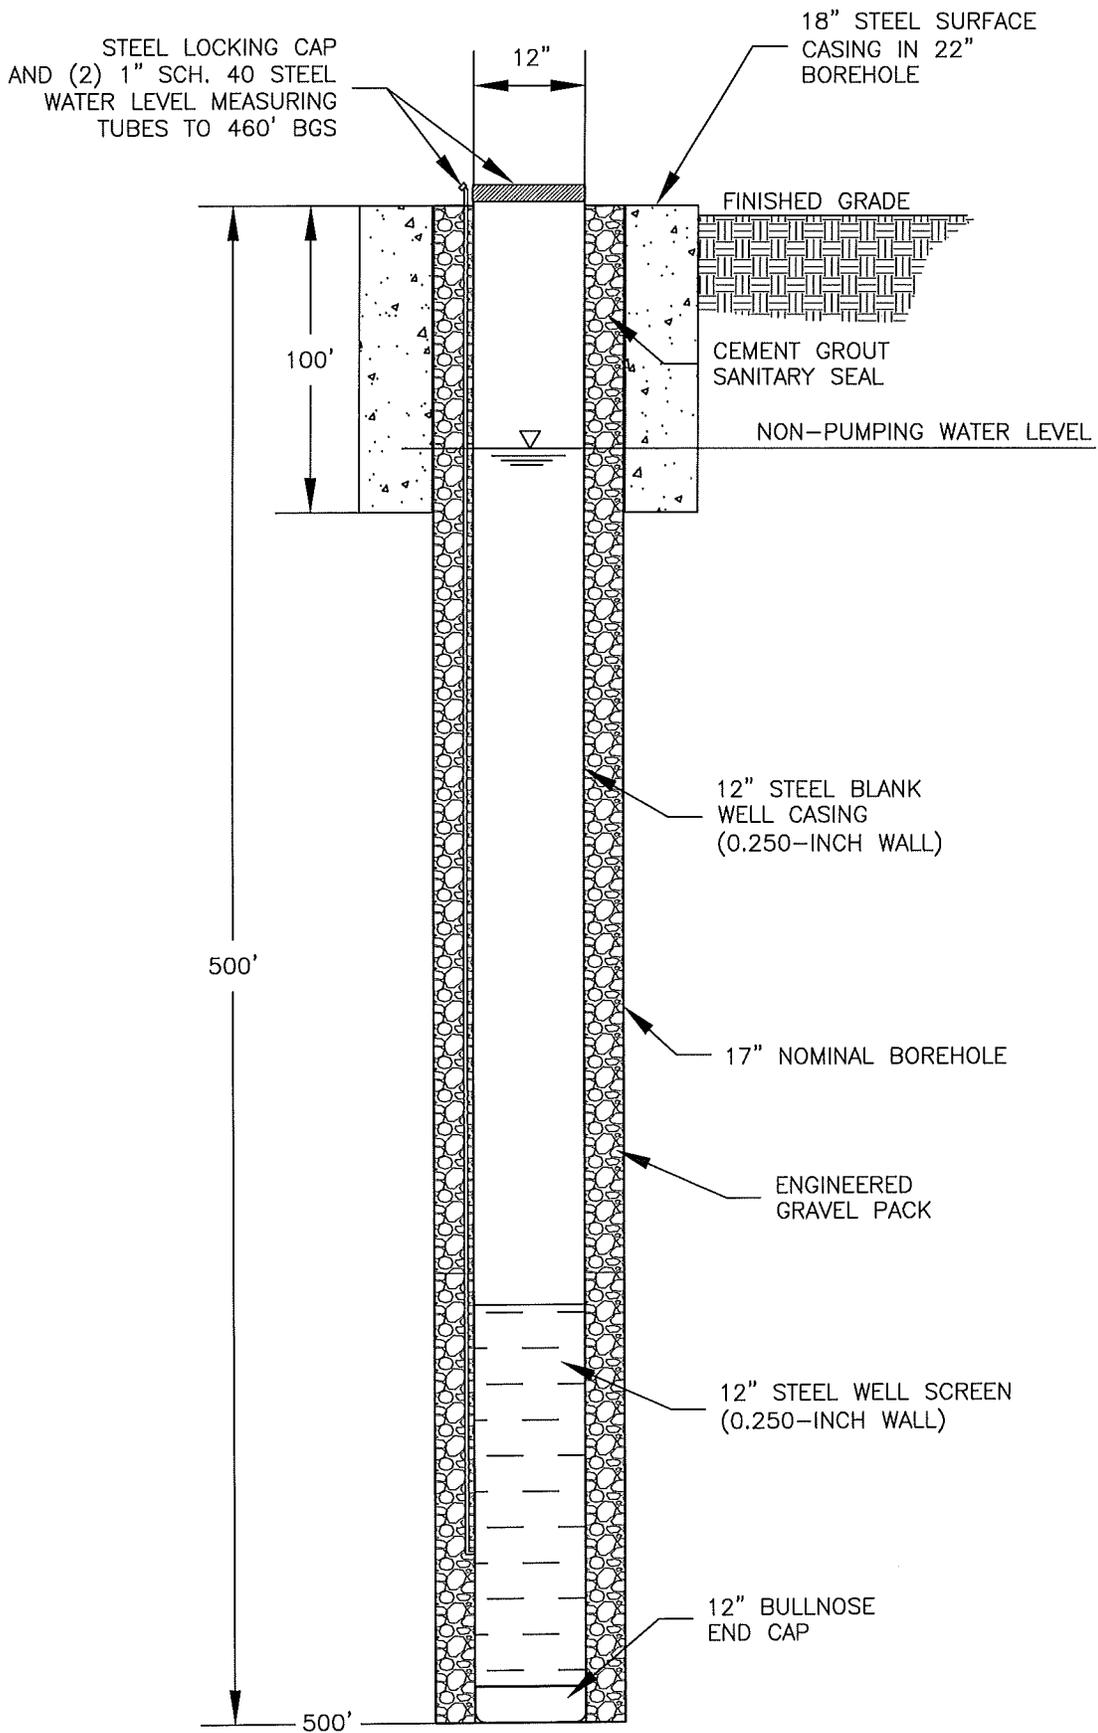

PO BOX 151178 • ELY, NEVADA 89315 • (775) 289-5353
 63 KEYSTONE AVENUE #206 • RENO, NEVADA 89503 • (775) 348-8624

BLM PLAN OF DEVELOPMENT
WELL CONSTRUCTION DIAGRAM
AUSTIN WATER SYSTEM IMPROVEMENTS

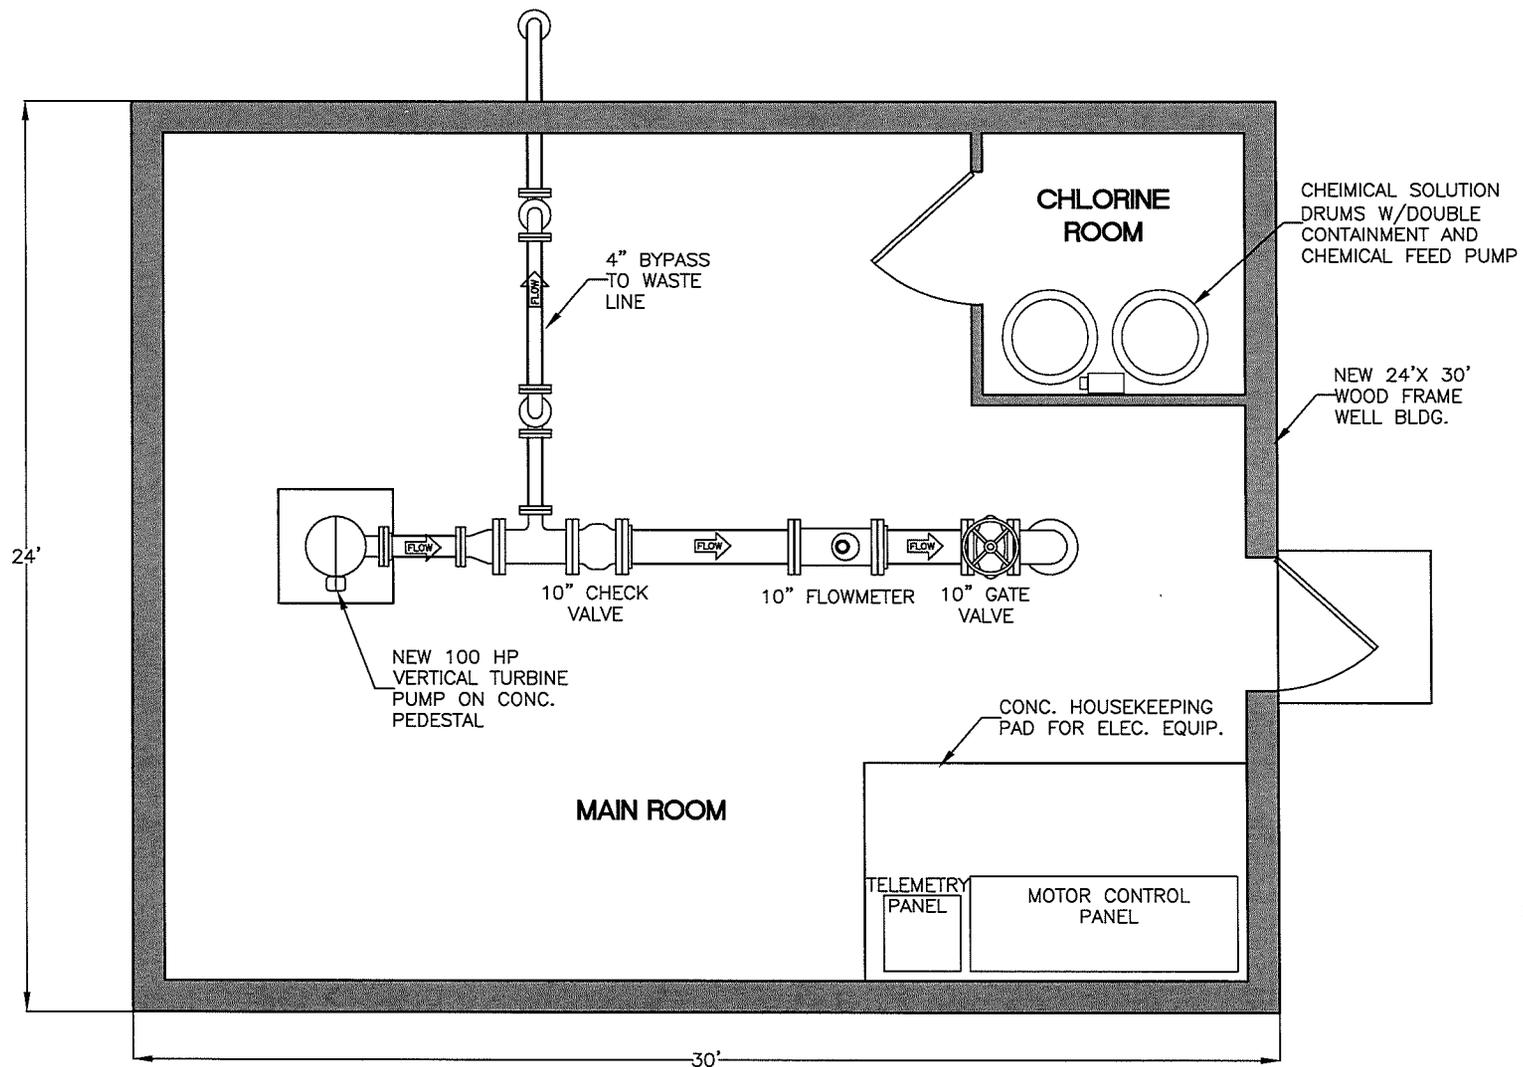


NEW WELL PLAN

SCALE: 1" = 5'



PO BOX 151178 • ELY, NEVADA 89315 • (775) 289-5353
 63 KEYSTONE AVENUE #205 • RENO, NEVADA 89503 • (775) 348-8624

BLM PLAN OF DEVELOPMENT
NEW WELL PIPING PLAN
AUSTIN WATER SYSTEM IMPROVEMENTS

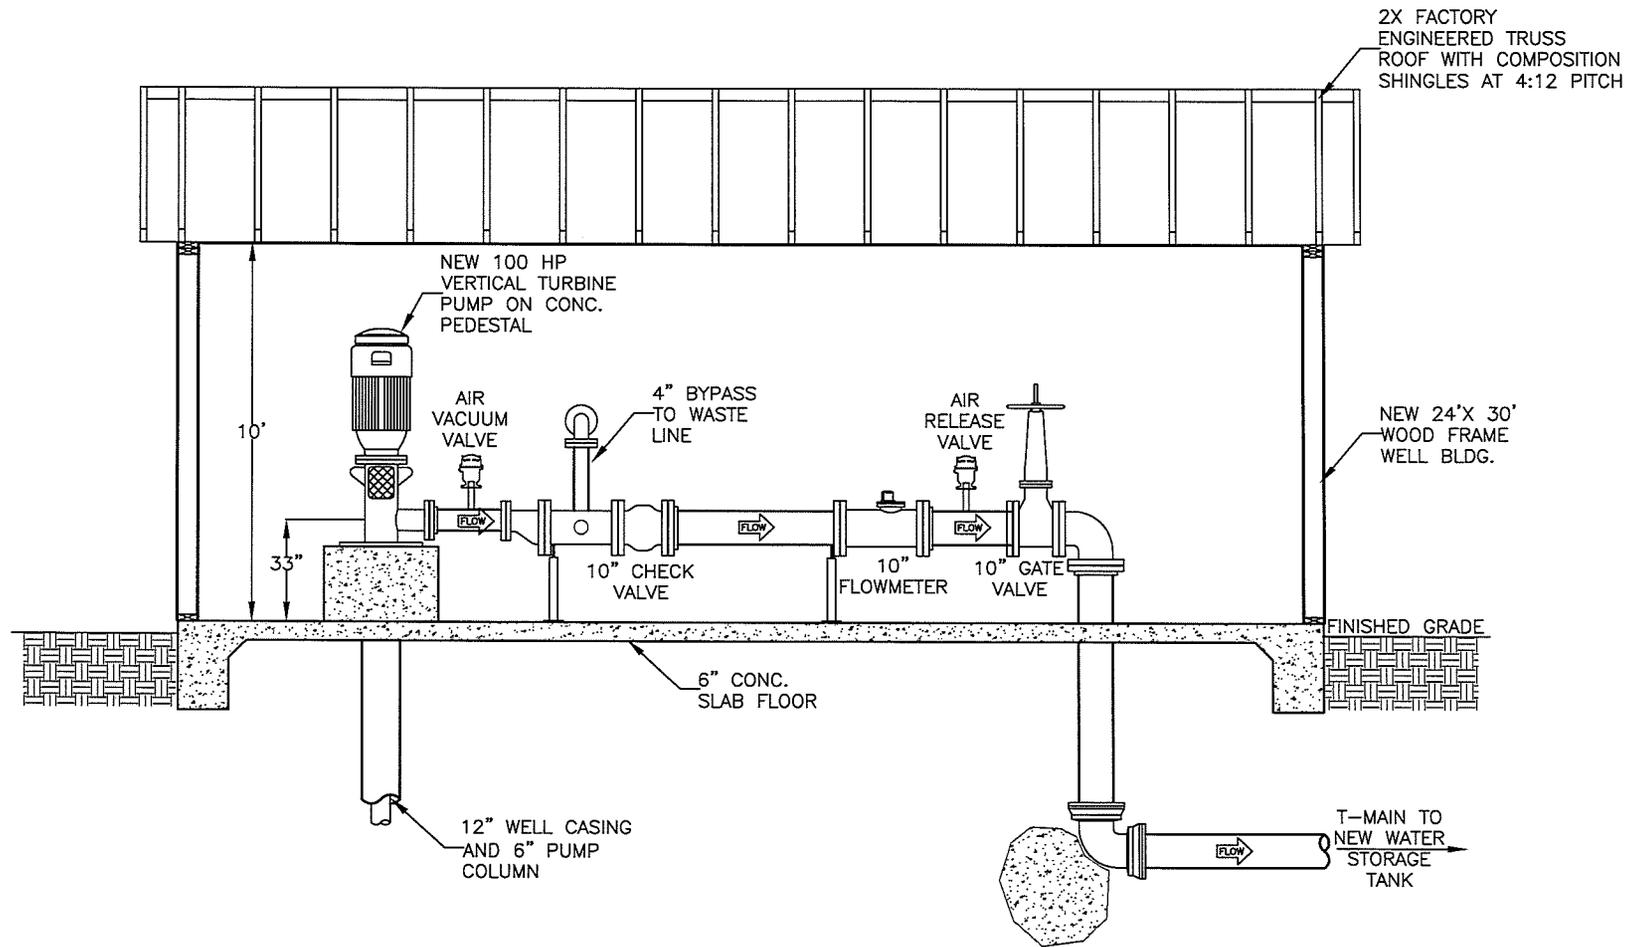


NEW WELL SECTION

SCALE: 1" = 5'



PO BOX 151178 • ELY, NEVADA 89315 • (775) 289-5353
 63 KEYSTONE AVENUE #206 • RENO, NEVADA 89503 • (775) 348-8624

BLM PLAN OF DEVELOPMENT
NEW WELL PIPING SECTION
AUSTIN WATER SYSTEM IMPROVEMENTS

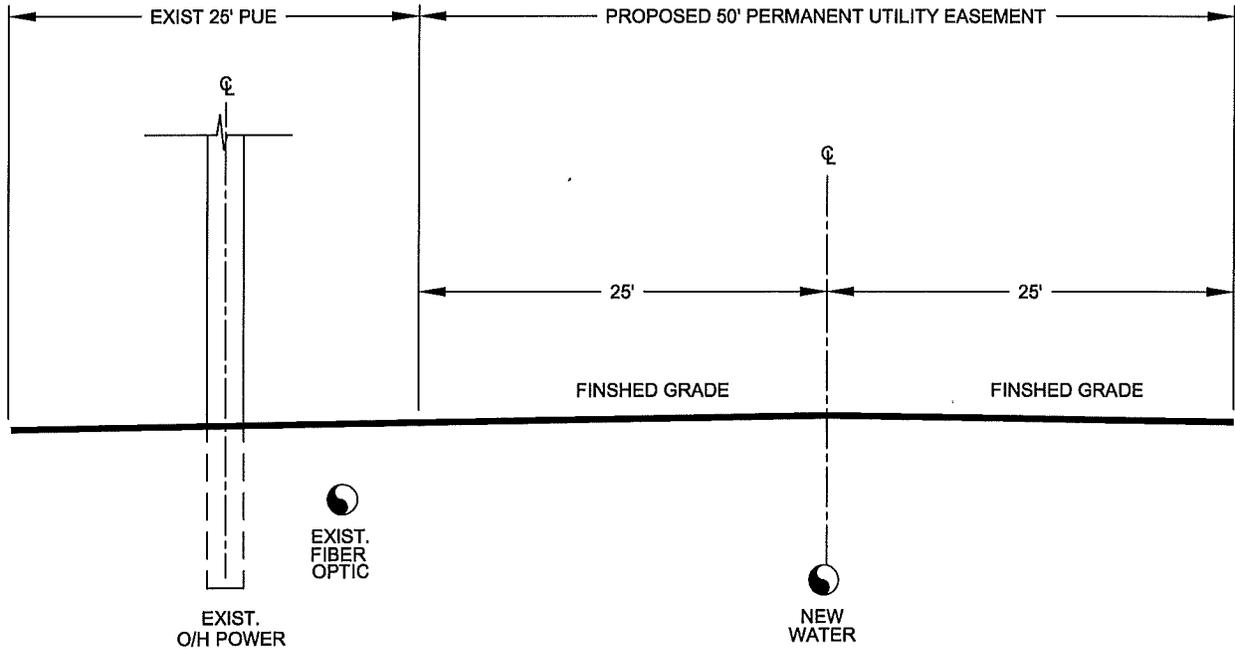

TYPICAL PIPELINE EASEMENT SECTION
NOT TO SCALE

**PROPOSED
PIPELINE EASEMENT**

Detail No.

DATE

REVISIONS

BY


Sheet No.

DATE	REVISIONS	BY



PO BOX 151178 • ELY, NEVADA 89315 • (775) 289-5353
63 KEYSTONE AVENUE #208 • RENO, NEVADA 89503 • (775) 348-8624

**BLM PLAN OF DEVELOPMENT
TYPICAL PIPELINE EASEMENT SECTION
AUSTIN WATER SYSTEM IMPROVEMENTS**

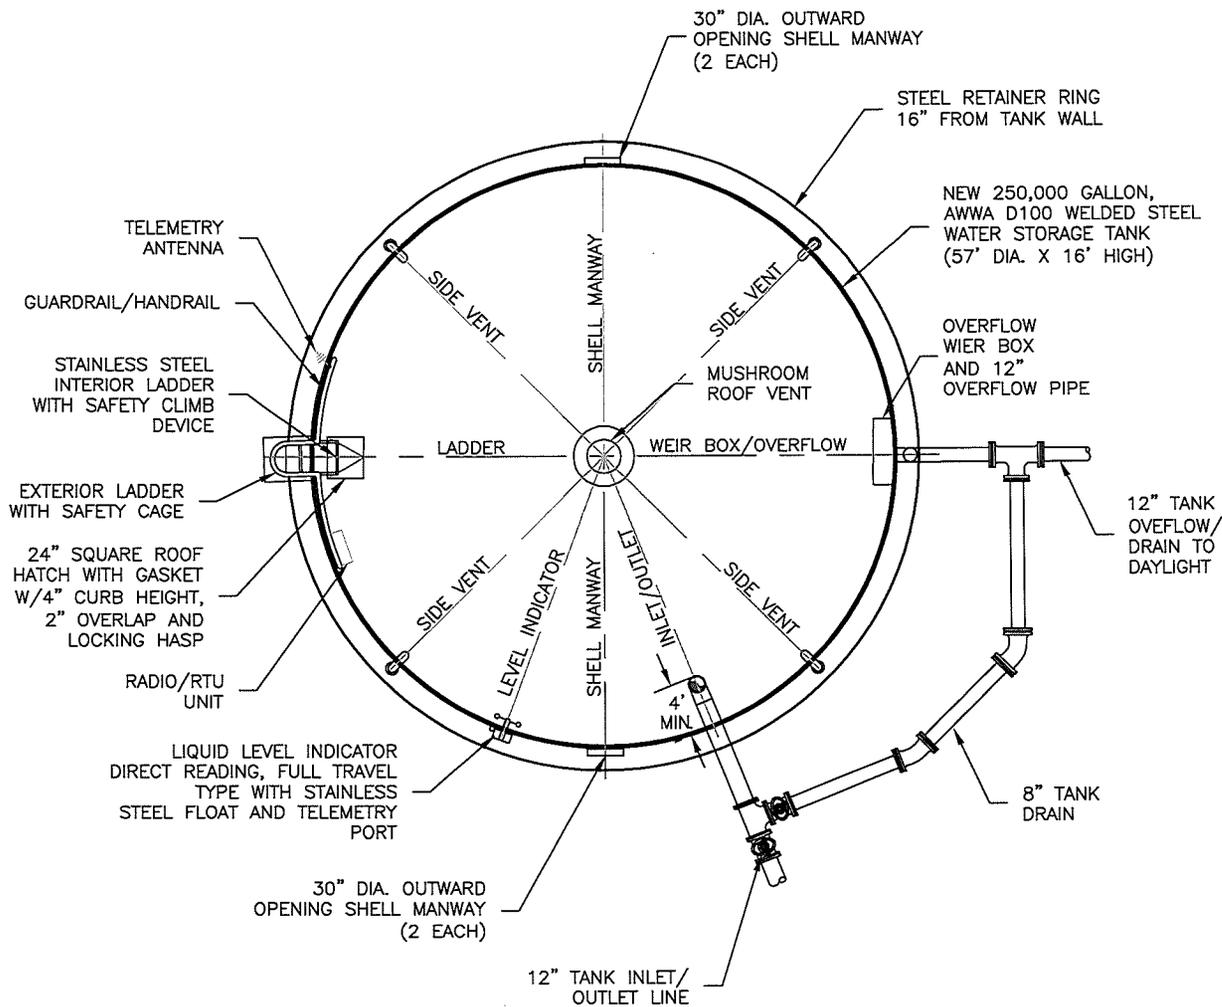


NOTE:
 A GEOTECHNICAL ENGINEER SHALL BE ON SITE DURING TANK PAD PREPARATION

TANK PIPING PLAN
 NOT TO SCALE



PO BOX 151178 • ELY, NEVADA 89315 • (775) 289-5353
 63 KEYSTONE AVENUE #206 • RENO, NEVADA 89503 • (775) 348-8624

BLM PLAN OF DEVELOPMENT
NEW WATER STORAGE TANK PLAN
 AUSTIN WATER SYSTEM IMPROVEMENTS

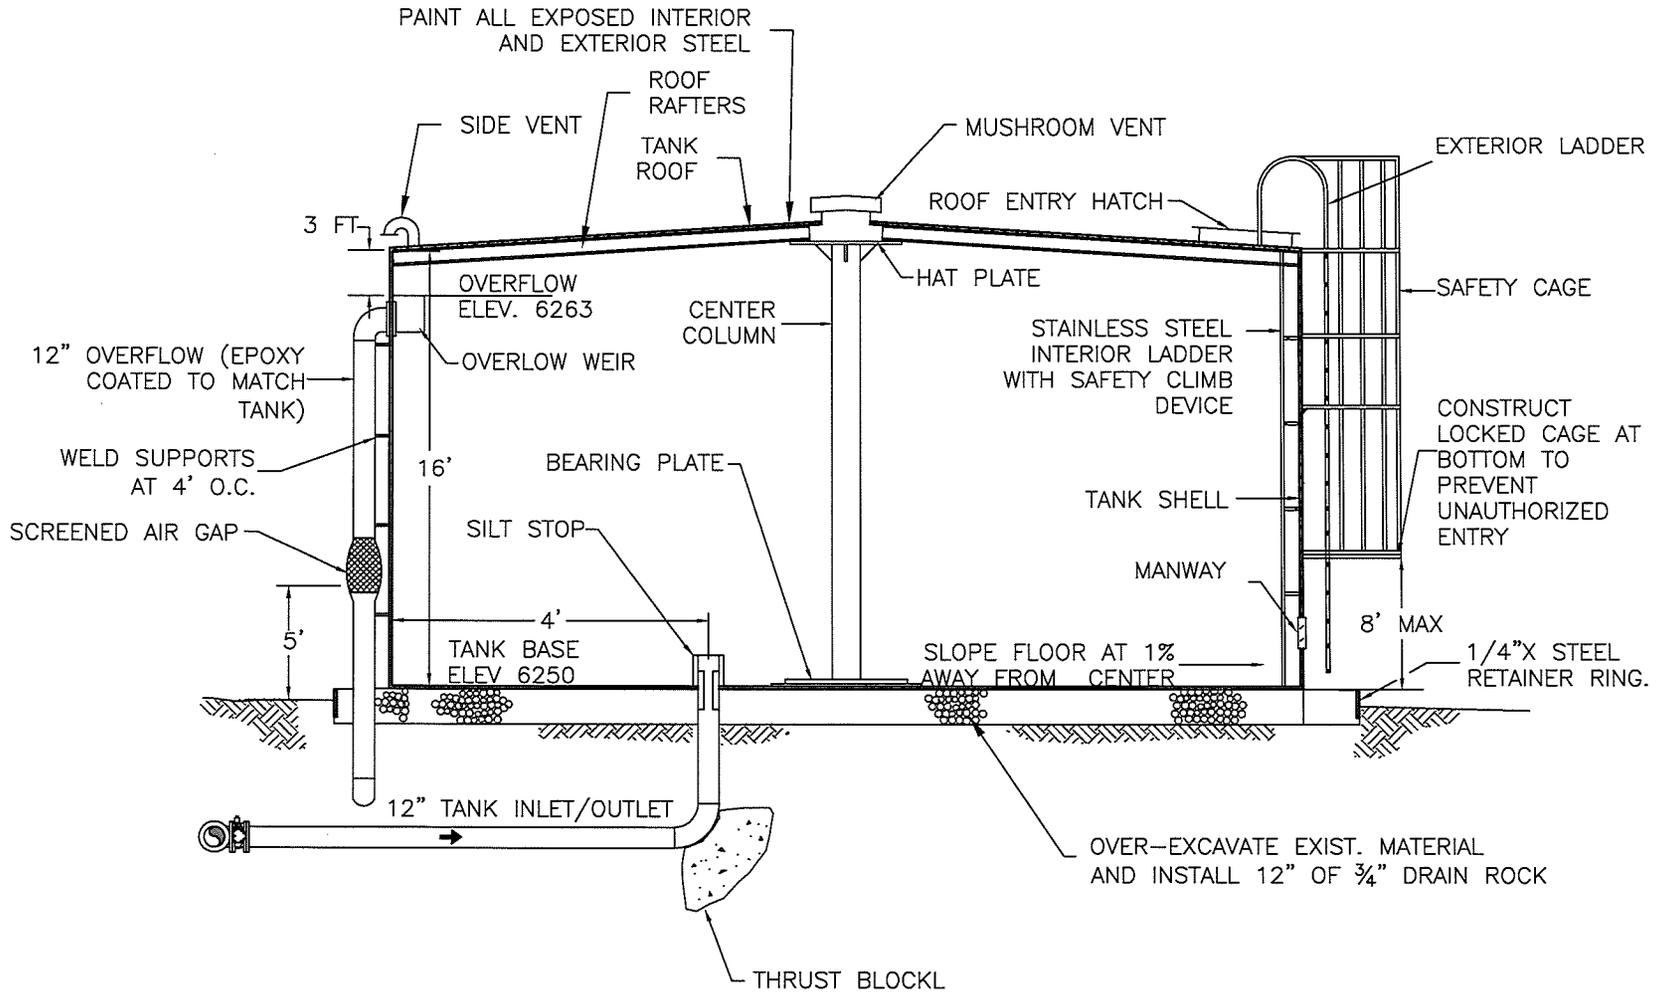


TANK SECTION

NOT TO SCALE



PO BOX 151178 • ELY, NEVADA 89315 • (775) 289-5353
 63 KEYSTONE AVENUE #206 • RENO, NEVADA 89503 • (775) 348-8624

BLM PLAN OF DEVELOPMENT
NEW WATER STORAGE TANK SECTION
AUSTIN WATER SYSTEM IMPROVEMENTS

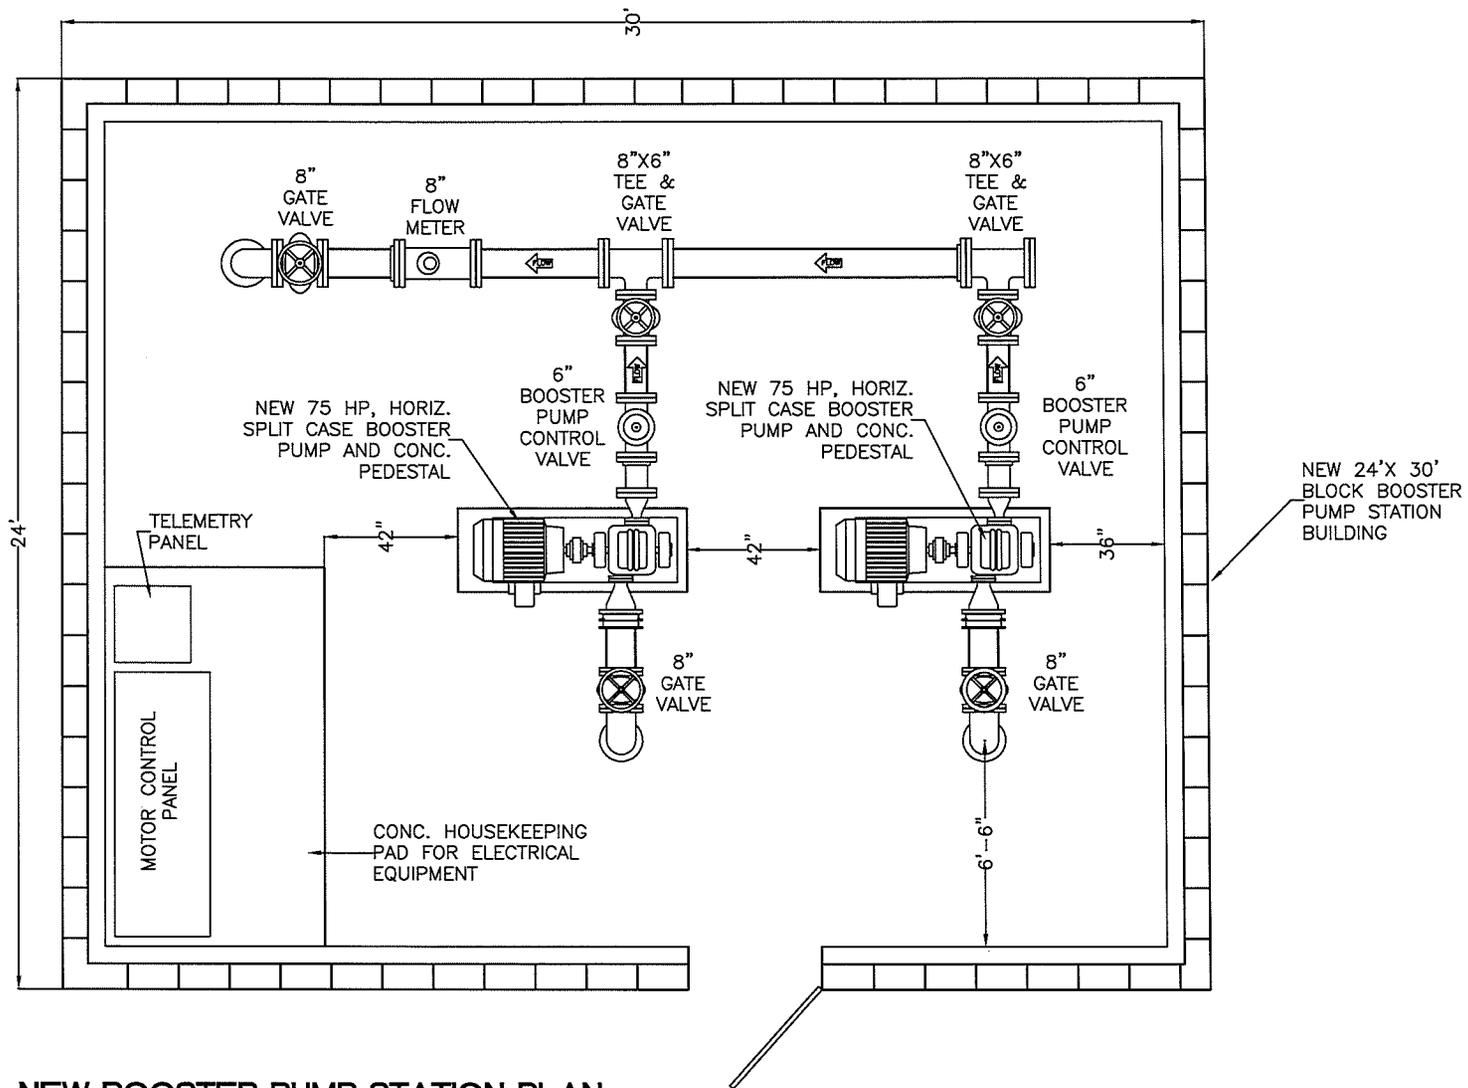


NEW BOOSTER PUMP STATION PLAN

SCALE: 1" = 5'



PO BOX 151178 • ELY, NEVADA 89315 • (775) 289-5353
 63 KEYSTONE AVENUE #206 • RENO, NEVADA 89503 • (775) 348-8624

BLM PLAN OF DEVELOPMENT
BOOSTER PUMP STATION PIPING PLAN
 AUSTIN WATER SYSTEM IMPROVEMENTS

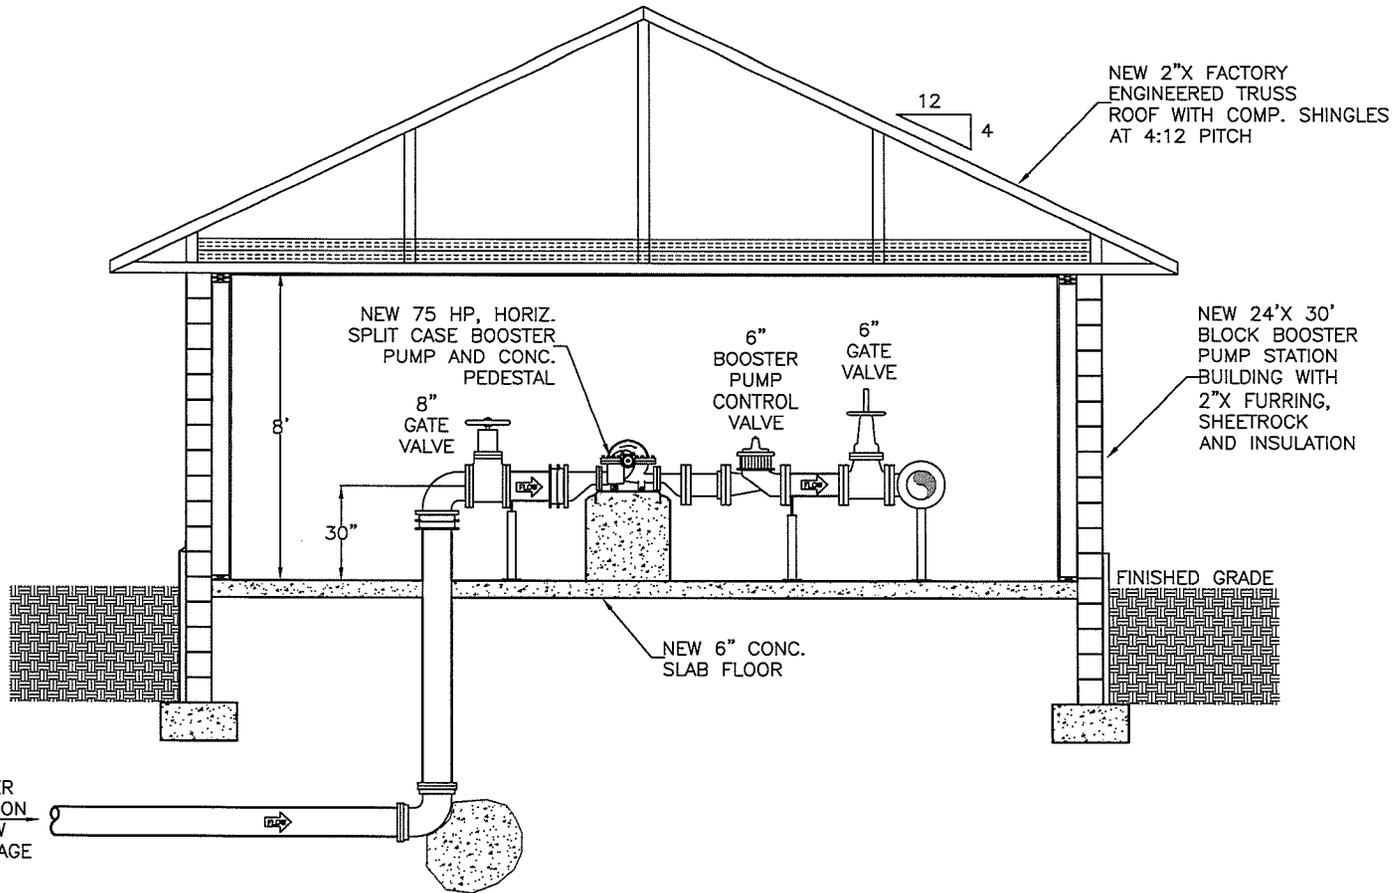


NEW BOOSTER PUMP SECTION
 SCALE: 1" = 5'



PO BOX 151178 • ELY, NEVADA 89315 • (775) 289-5353
 63 KEYSTONE AVENUE #206 • RENO, NEVADA 89503 • (775) 348-8624

BLM PLAN OF DEVELOPMENT
BOOSTER PUMP STATION PIPING SECTION
 AUSTIN WATER SYSTEM IMPROVEMENTS

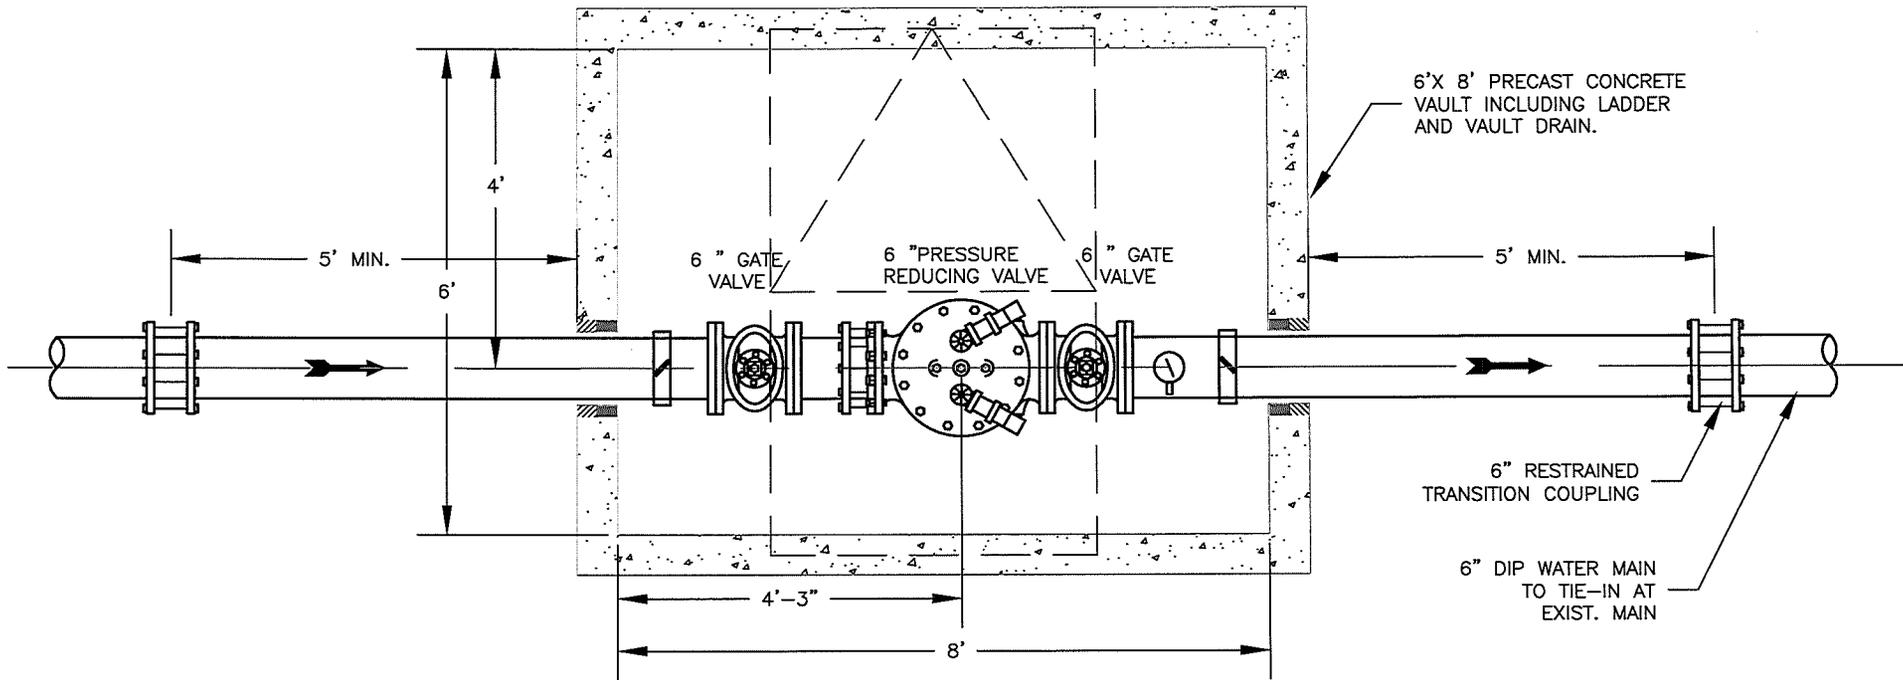


PRV PLAN DETAIL

NOT TO SCALE



PO BOX 151178 • ELY, NEVADA 89315 • (775) 289-5353
 63 KEYSTONE AVENUE #206 • RENO, NEVADA 89503 • (775) 348-8624

BLM PLAN OF DEVELOPMENT
NEW PRV STATION PIPING PLAN
 AUSTIN WATER SYSTEM IMPROVEMENTS

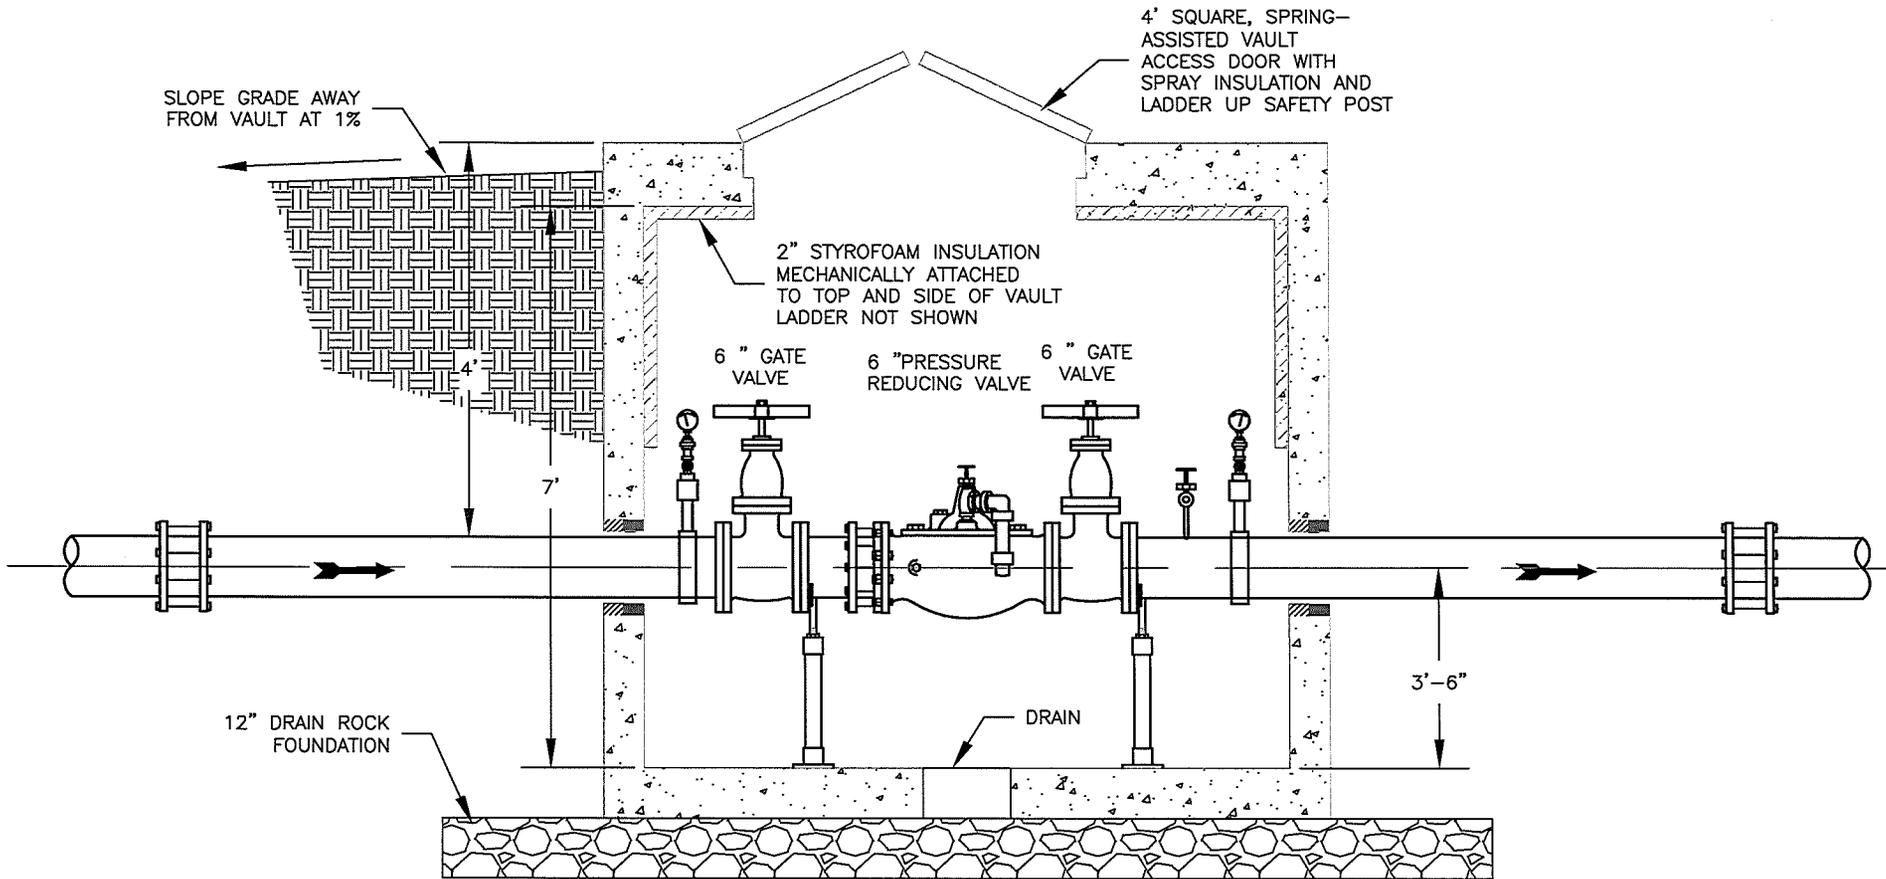

PRV SECTION DETAIL

NOT TO SCALE



PO BOX 151178 • ELY, NEVADA 89315 • (775) 289-5353
 63 KEYSTONE AVENUE #206 • RENO, NEVADA 89503 • (775) 348-8624

BLM PLAN OF DEVELOPMENT
NEW PRV STATION PIPING SECTION
AUSTIN WATER SYSTEM IMPROVEMENTS